

BLD-02830 - New Central Plant - Bldg 14
OSHPD 1 - SPC 5 NPC 4

BLD-03685 - East Wing Addition - Bldg 06A
OSHPD 1 - SPC 4 NPC 2

BLD-02105 - Meeting Room Addition - Bldg 08A
OSHPD 1 - SPC 3 NPC 2

BLD-03683 - Womens Health Center - Bldg 08
OSHPD 1 - SPC 3 NPC 2

BLD-02100 - North Wing - Bldg 03
OSHPD 1 - SPC 2 NPC 2

BLD-03768 - West Wing - North - Bldg 02C
OSHPD 1 - SPC 2 NPC 2

BLD-05312 - Mental Health Building - Bldg 11
OSHPD 5 - Acute Psych

BLD-05368 - Physical Rehabilitation Utility Vault - Bldg 07A
OSHPD 1 - SPC 4s NPC 2

BLD-06788 PCU Addition - Bldg 07C
OSHPD 1 - Under Construction

BLD-03678 - Old Administration Building - Bldg 10
OSHPD 1 - SPC 2 NPC 2

BLD-02104 - Physical Rehabilitation Unit - Bldg 07
OSHPD 1 - SPC 4 NPC 2

BLD-06787 Neuro ICU Addition - Bldg 07B
OSHPD 1 - Under Construction

BLD-05764 - Emergency Generator 1 - Bldg 14A
OSHPD 1 - SPC 5 NPC 4

BLD-05765 - Emergency Generator 2 - Bldg 14B
OSHPD 1 - SPC 5 NPC 4

BLD-07007 South Loading Dock - Bldg 17
OSHPD 1 - SPC 4D NPC 4

BLD-07153 Oxygen Yard - Bldg 14C
OSHPD 1 - SPC N/A NPC 4

BLD-07008 Utility Trellis - Bldg 18
OSHPD 1 - SPC 5 NPC 4

BLD-02102 - Central Plant & Cooling Plant Expansion - Bldg 05
OSHPD 1 - SPC 4 NPC 2

BLD-02098 - Emergency Generator Building - Bldg 01
OSHPD 1 - SPC 4 NPC 4

BLD-02829 - Heart and Vascular Center - Bldg 13
OSHPD 1 - SPC 5 NPC 4

BLD-07070 Tunnel / Storage Room - Bldg 19
OSHPD 1 - SPC 5 NPC 4

BLD-05510 - MRI / Angio Addition - Bldg 15
OSHPD 1 - SPC 4 NPC 2

BLD-05336 - ED/CCU and ACNU Building - Bldg 12
OSHPD 1 - SPC 5 NPC 4

BLD-02103 - East Wing - Bldg 06
OSHPD 1 - SPC 4 NPC 2

BLD-05678 - Utility Tunnel - Bldg 16
OSHPD 1 - Utility Tunnel - SPC N/A NPC 2

BLD-07071 ER Substation - Bldg 20
OSHPD 1 - SPC 5s NPC 4

BLD-02101 - South Wing - Bldg 04
OSHPD 1 - SPC 2 NPC 2

BLD-03767 - West Wing - East - Bldg 02B
OSHPD 1 - SPC 2 NPC 2

BLD-06867 Main Entry Canopy - Bldg 09A
OSHPD 1 - SPC 4 NPC 2

BLD-02622 - Main Entry - Bldg 09
OSHPD 1 - SPC 4 NPC 2

BLD-02099 - West Wing - West - Bldg 02A
OSHPD 1 - SPC 2 NPC 2


Grossmont Hospital Facility No. 12322

2/3/2026

LEGEND:

	OSHPD 1		Utility Tunnel
	OSHPD 1 - SPC 1 or SPC 2		Building Boundary Without Seismic Separation
	OSHPD 2 or OSHPD 5		Seismic Separation

Page 1 of 2

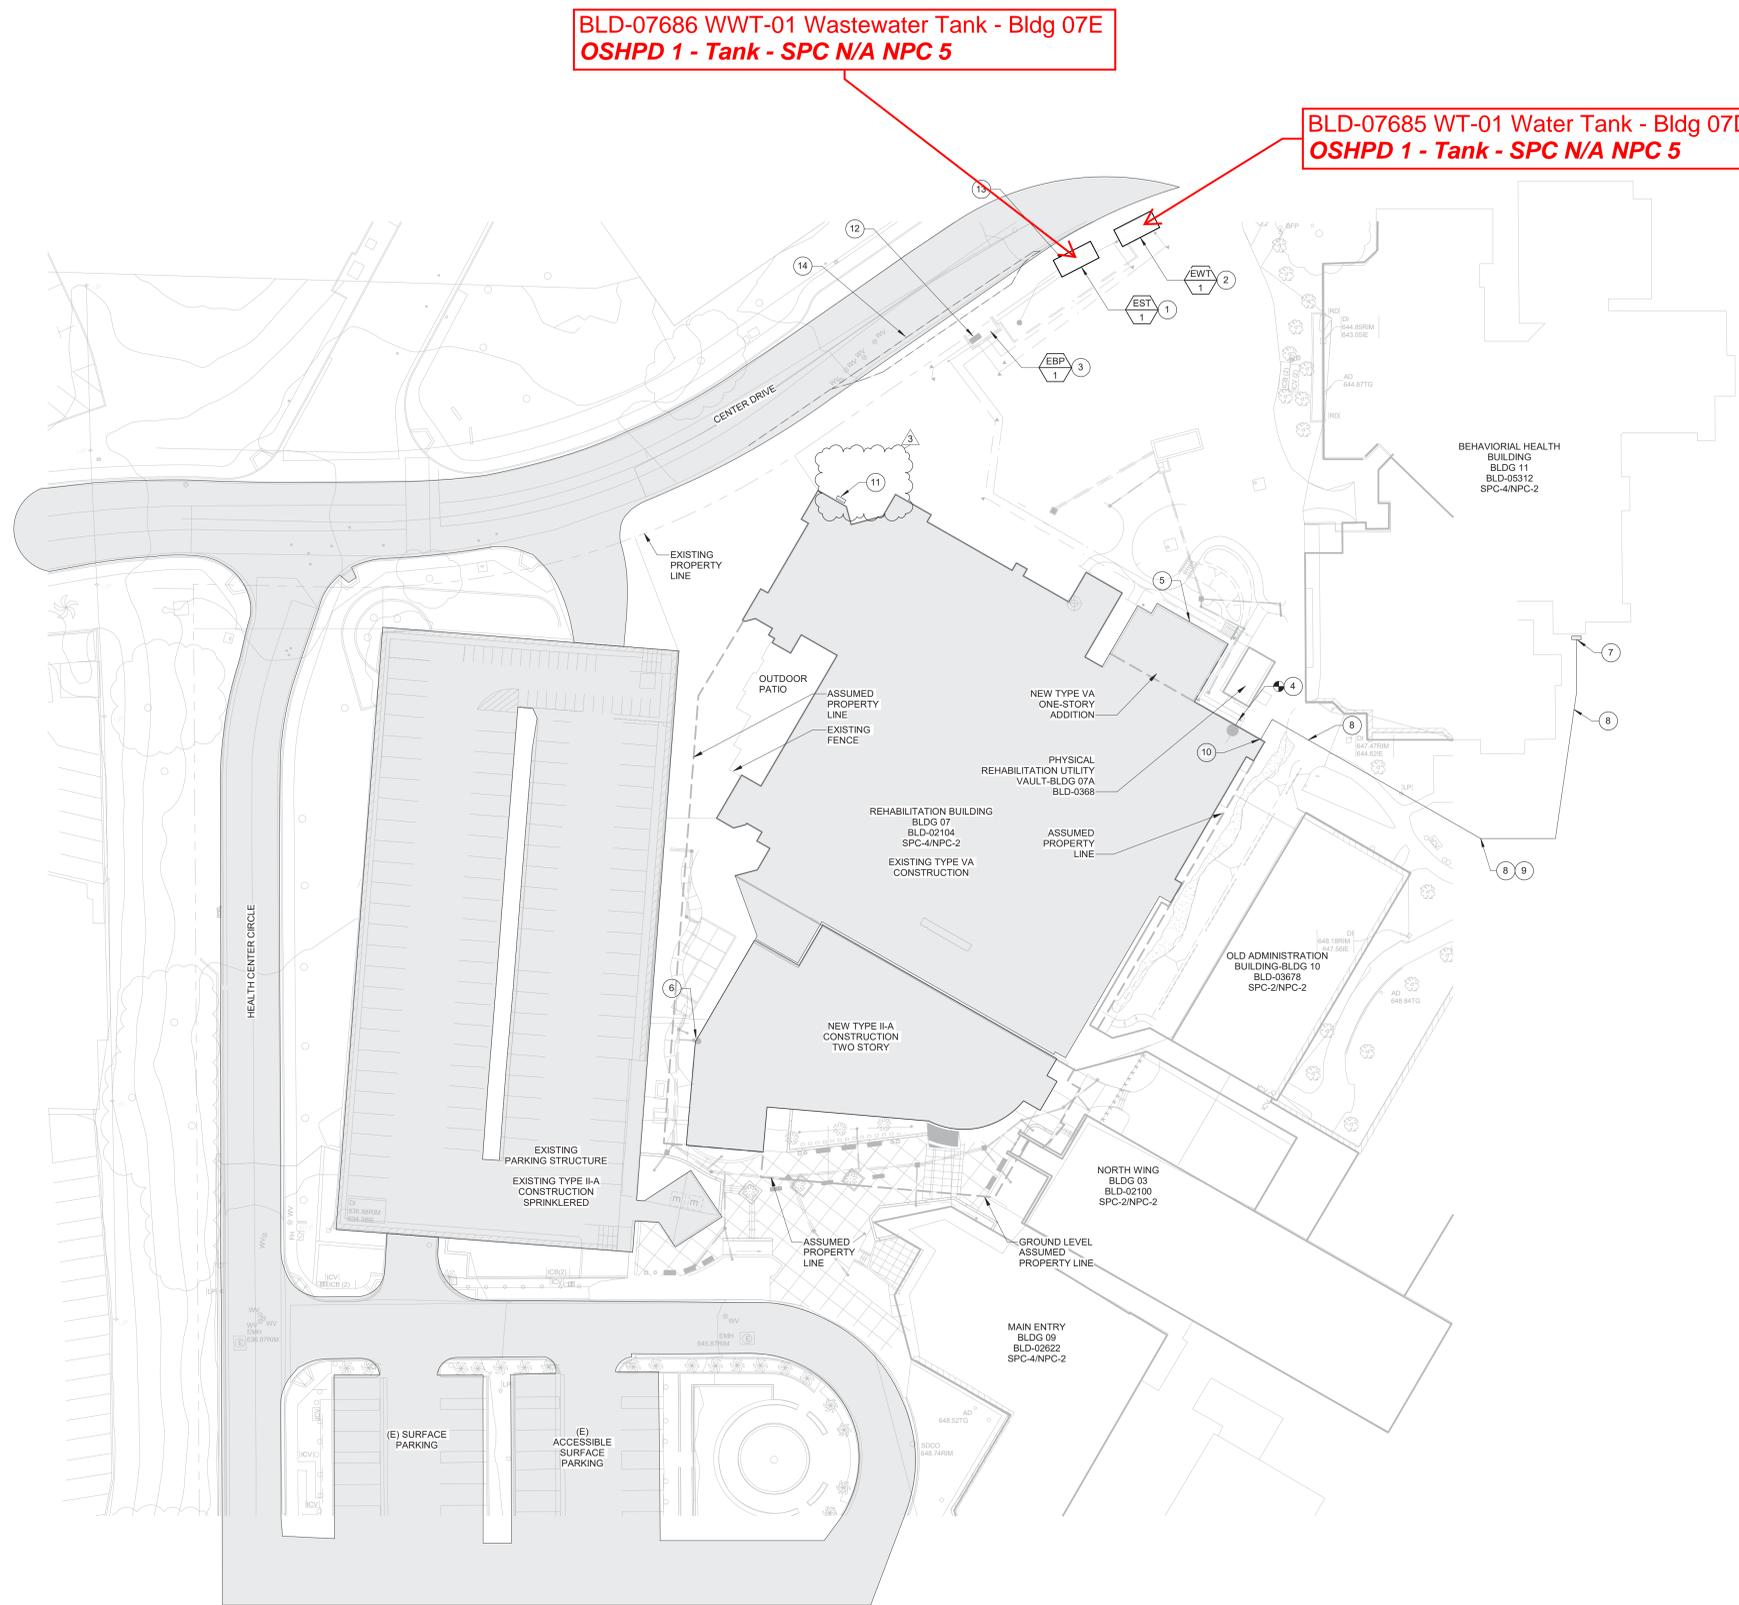

**BLD-07686 WWT-01 Wastewater Tank - Bldg 07E
OSHPD 1 - Tank - SPC N/A NPC 5**

**BLD-07685 WT-01 Water Tank - Bldg 07D
OSHPD 1 - Tank - SPC N/A NPC 5**

1 PLUMBING SITE PLAN
SCALE 1" = 30'-0"

GENERAL NOTES

1. EMERGENCY SEWER TANK 5,000 GALLONS.
2. EMERGENCY WATER TANK 5,000 GALLONS.
3. UTILITY YARD WITH VERTICAL TURBINE BOOSTER PUMPS, CONTROL PANELS, AND TANK VENTS.
4. 3" SD W/ 4" OSD W/ DN-1 THAT DISCHARGES TO SITE STORM FILTER SYSTEM.
5. 3" SD & 4" OSD W/ DN-1 THAT DISCHARGES TO SITE STORM FILTER SYSTEM.
6. TWO (2) 6" SD/OSD WITH DN-1 THAT DISCHARGES TO SITE STORM FILTER SYSTEM.
7. USE EXISTING SHUT OFF VALVE AS ISOLATION FROM BULK STORAGE. INSTALL NEW TEE WITH SHUT OFF VALVE FROM UNDERGROUND ROUTING TO REHABILITATION BUILDING AND INSTALL NEW SHUT OFF VALVE FOR BEHAVIORAL HEALTH BUILDING.
8. 1-1/4" UNDERGROUND OXYGEN TYPE K WITH 6 MIL POLY WRAP. EXISTING ROUTING TO BE FIELD CONFIRMED. PROVIDE 36" BURIAL DEPTH PER NFPA 99, 5.1.10.11.5.5.
9. JOIN ELECTRICAL TRENCH HERE.
10. EXTEND NEW OXYGEN INTO MECHANICAL ROOM AND RE-FEED TO EXISTING OXYGEN RISER. VALVE AND CAP EXISTING RISER FROM BEHAVIORAL HEALTH BUILDING.
11. EMERGENCY OXYGEN CONNECTION.
12. EMERGENCY DOMESTIC WATER FILL AT YARD CONNECTION. SEE DETAIL 3, SHEET P-503, KEYNOTE 7.
13. EMERGENCY SEWER TANK ACCESS PUMP OUT LOCATION. SEE DETAIL 3, SHEET P-503, KEYNOTE 11.
14. STREET PULL OUT AREA FOR EMERGENCY VEHICLE.

KEYNOTES



MASCARI WARNER DINH
architects


1717 Kettner Blvd., Suite 100
San Diego, California 92101
619.814.0080 Fax 619.814.0081



Dufoe
consulting engineers
10580 Torrey Street, Suite 103 San Diego, CA 92121
658-368-8630 Fax 658-517-3293 www.doe-inc.net



HCAI NO: H211394-37-00

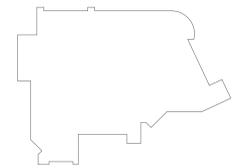

KEY PLAN



5555 GROSSMONT CENTER DR.
LA MESA, CA 91942

SHARP GROSSMONT HOSPITAL NEUROSCIENCES CENTER
INCREMENT #2 PACKAGE

TITLE PLUMBING SITE PLAN

PROJECT NO. 2021001.10

REV.	DESCRIPTION	DATE
1	HCAI SUBMITTAL	03/16/22
1	BACKCHECK 1	09/08/2022
2	BACKCHECK 2	11/30/2022
3	BACKCHECK 3	02/28/2023