


Petaluma Valley Hospital Facility No. 14568

3/19/2026

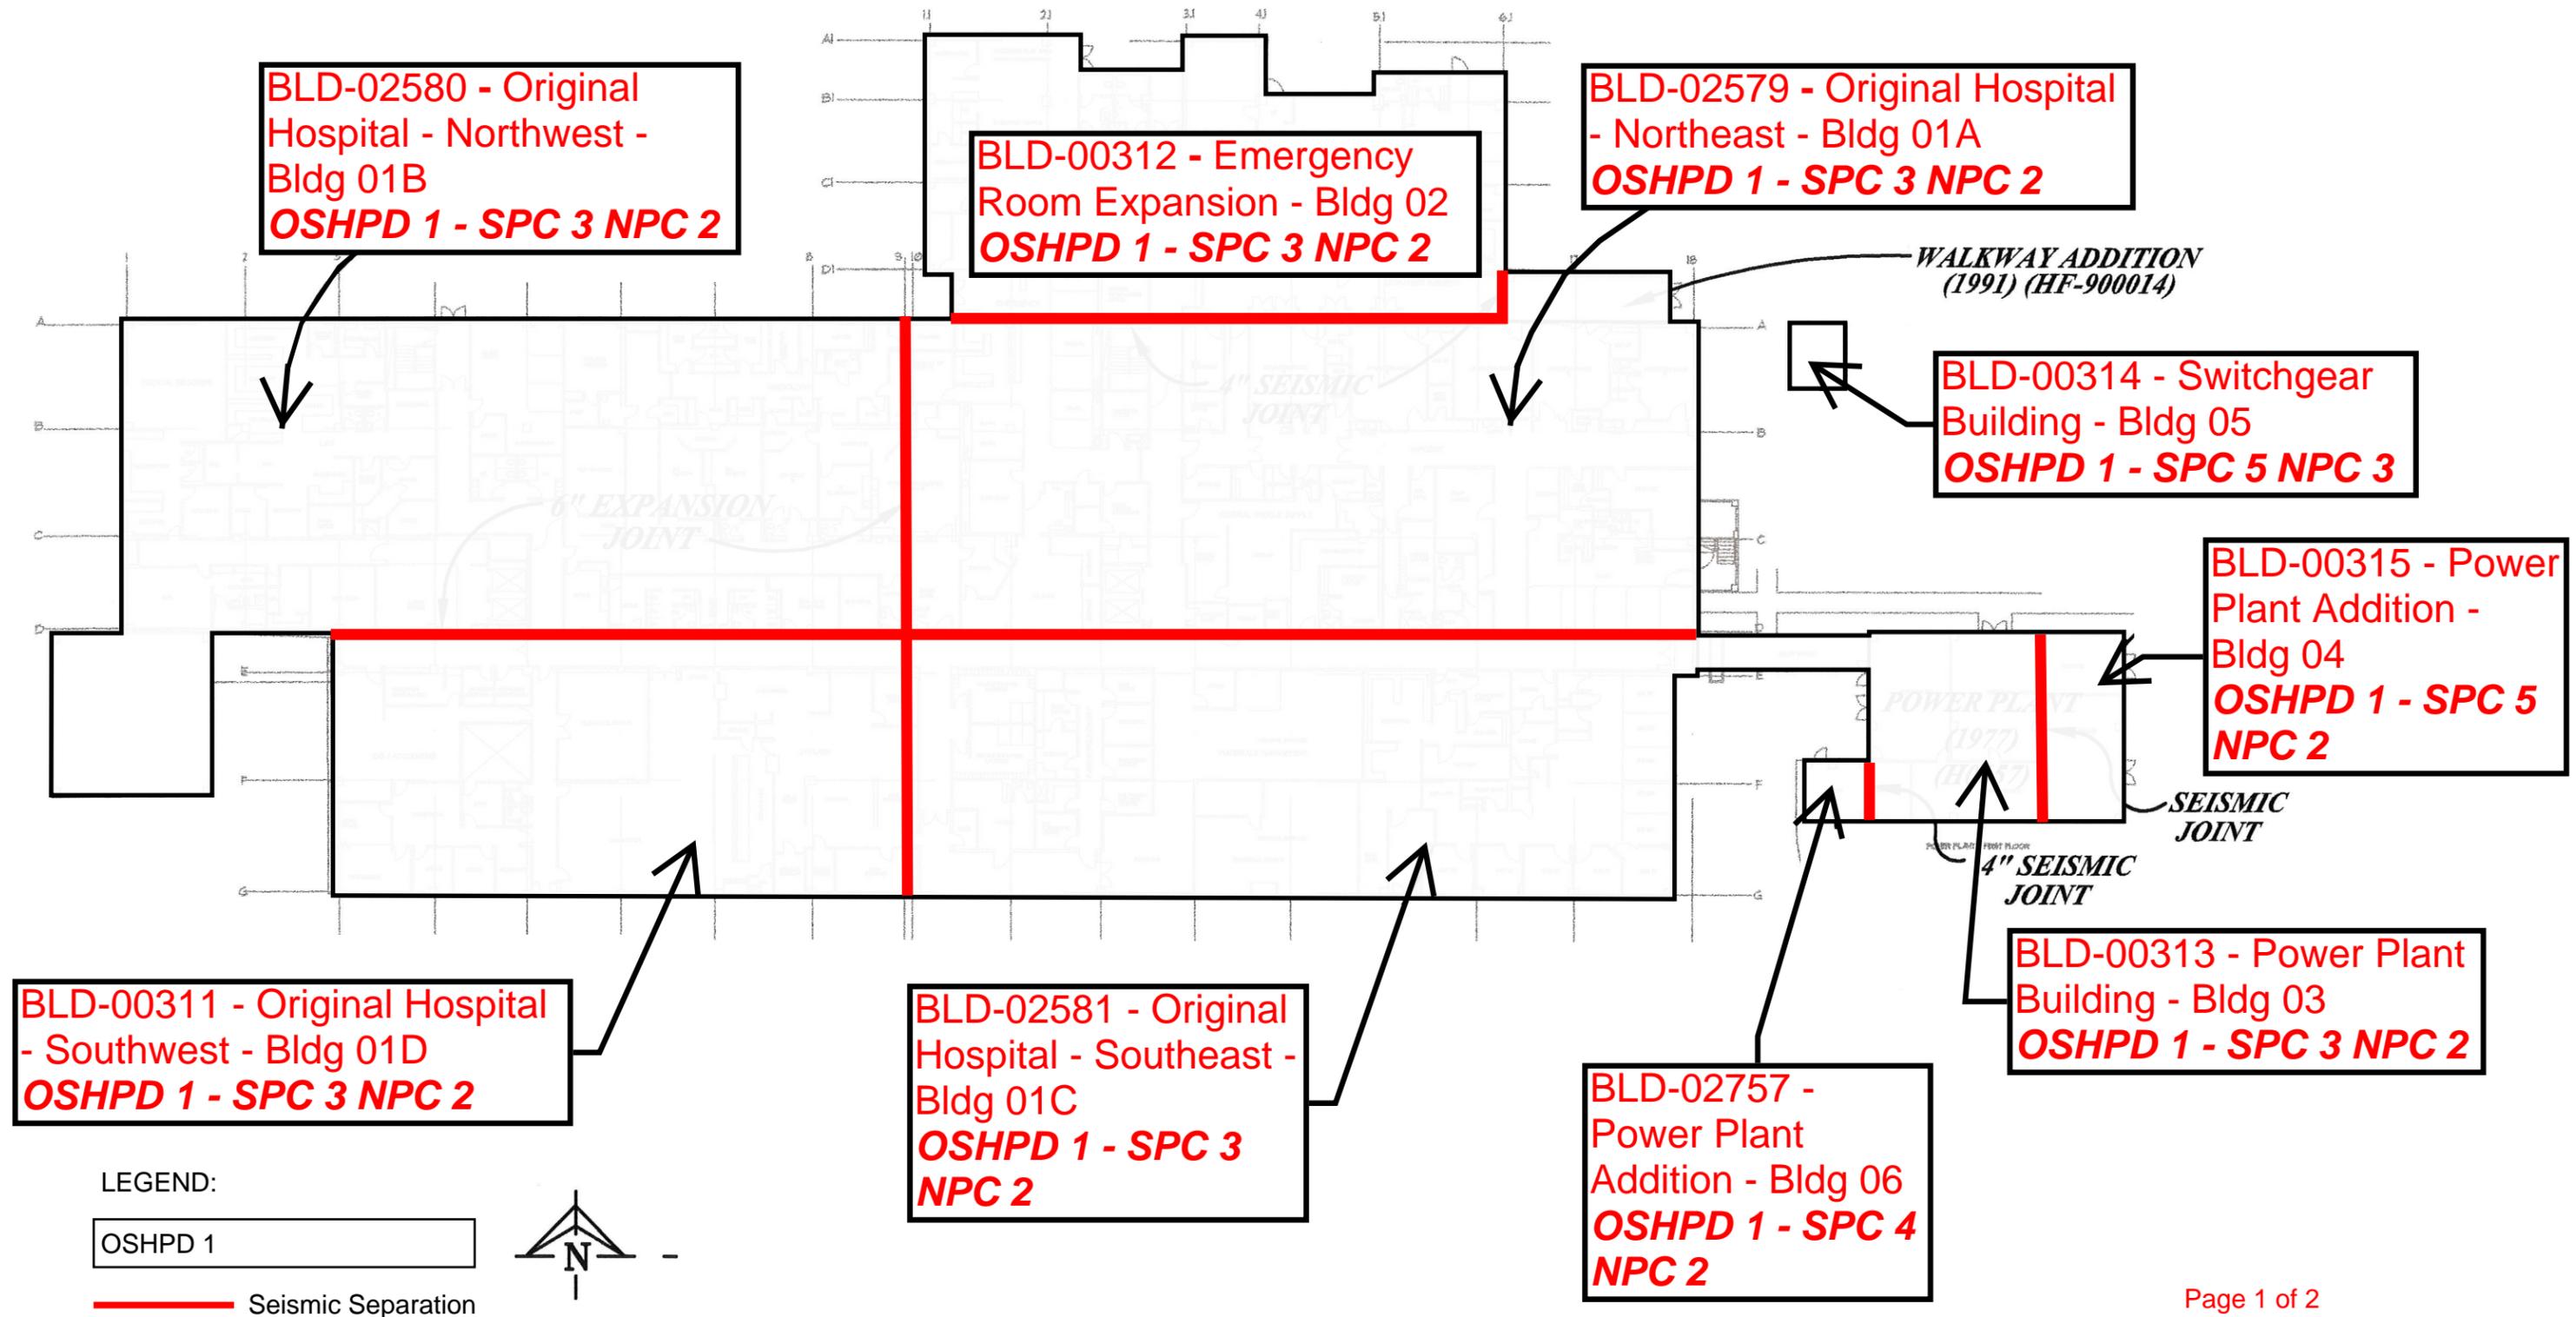

- NOTES**
- 1. [INSERT TEXT HERE]
 - 2. [INSERT TEXT HERE]

- GENERAL NOTES**
- 1. [INSERT TEXT HERE]
 - 2. [INSERT TEXT HERE]

HCAI NO.: S260675-49-00

OWNER:



Degenkolb
 DEGENKOLB ENGINEERS
 1100 Town and Country Road, Suite 1388
 Orange, CA 92668
 657.999.7400 PHONE
 www.degenkolb.com
 DE Job Number: C4519005.00

Consultants
P2S ENG
 5000 East Spring Street, Suite 800
 Long Beach, CA 90815
 T: 562.497.2999
 F: 562.497.2970
 p2sinc.com
 P2S #: J25-0725



Revision		
No	Description	Date

KEY PLAN

Project
Providence Petaluma Valley Hospital
 400 N. McDowell Blvd, Petaluma, CA 94954

NOT FOR CONSTRUCTION

Sheet Title: **SITE PLAN**

Scale: 1" = 30'-0"
 Job Number: XXXX
 Drawn by: Author
 Design by: Designer
 Checked by: Checker
 Date: Month Day, Year
 Drawing Number:


P101

of Sheets

BLD-07825 WWT-01
Wastewater Tank- Bldg 08
OSHPD 1 - Future

BLD-07824 WT-01 Water Tank
- Bldg 07
OSHPD 1 - Future

BLD-07826 FT-01
Fuel Tank - Bldg 09
OSHPD 1 - Tank -
SPC N/A NPC 5

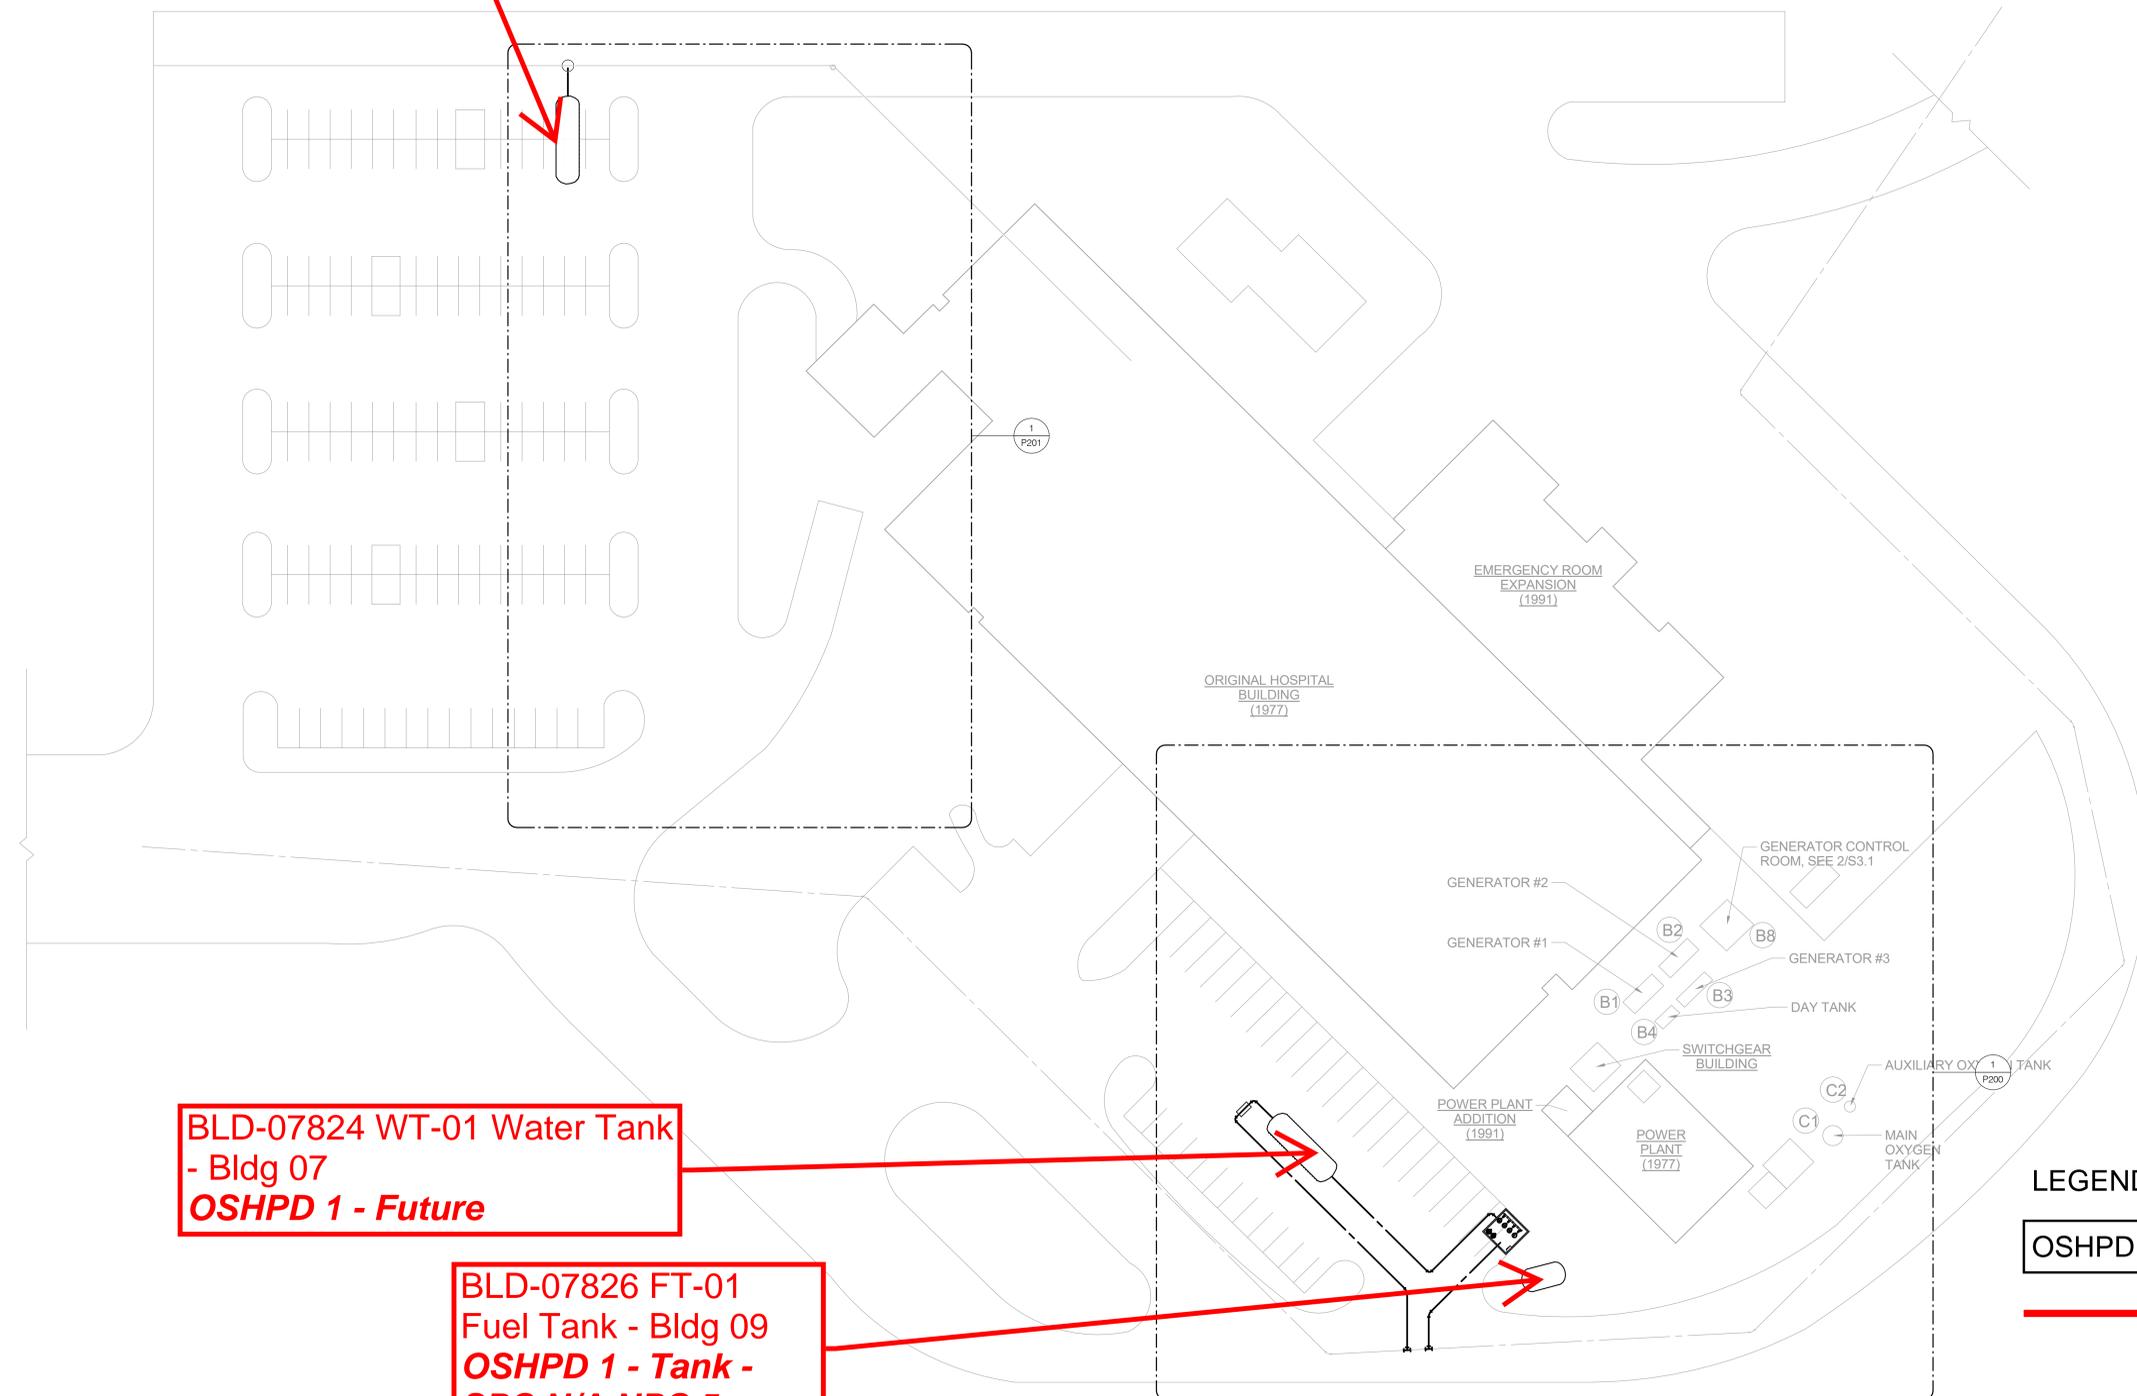

LEGEND:
 OSHPD 1
 Seismic Separation

2/26/2008 12:32:45 PM Providence Petaluma Valley NPC-5 Compliance/C4519005.00_Petaluma Valley NPC-5_P25 [25-0725].vt
 Autodesk Docs/125-0725 Providence Petaluma Valley NPC-5 Compliance/C4519005.00_Petaluma Valley NPC-5_P25 [25-0725].vt